




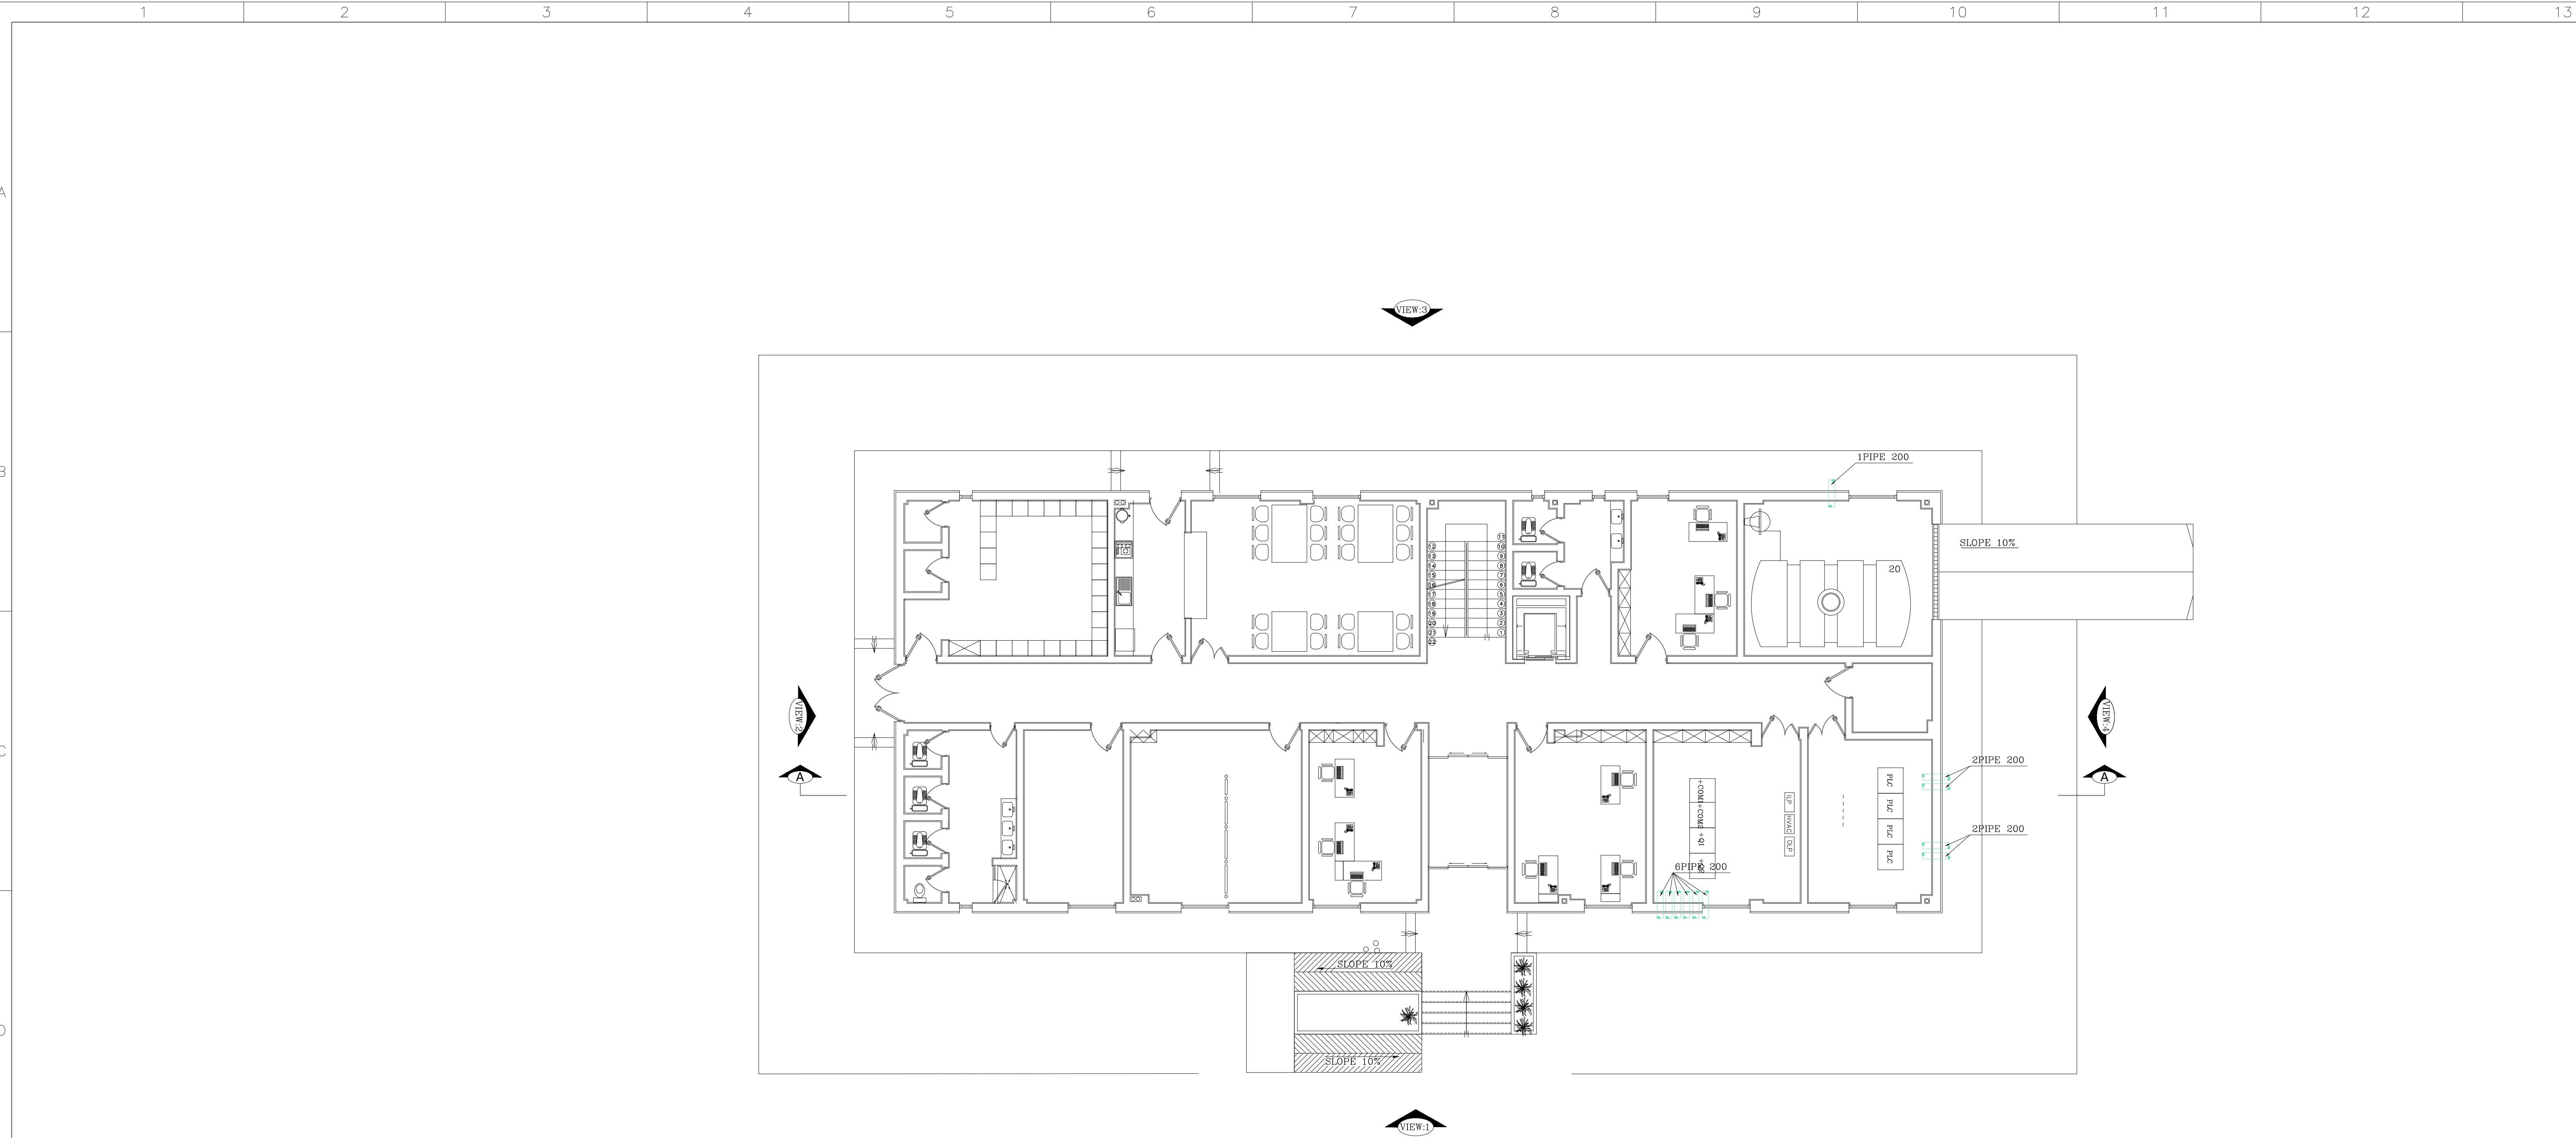

GROUND FLOOR PLAN & FURNITURE & PIPING
SC:1/150

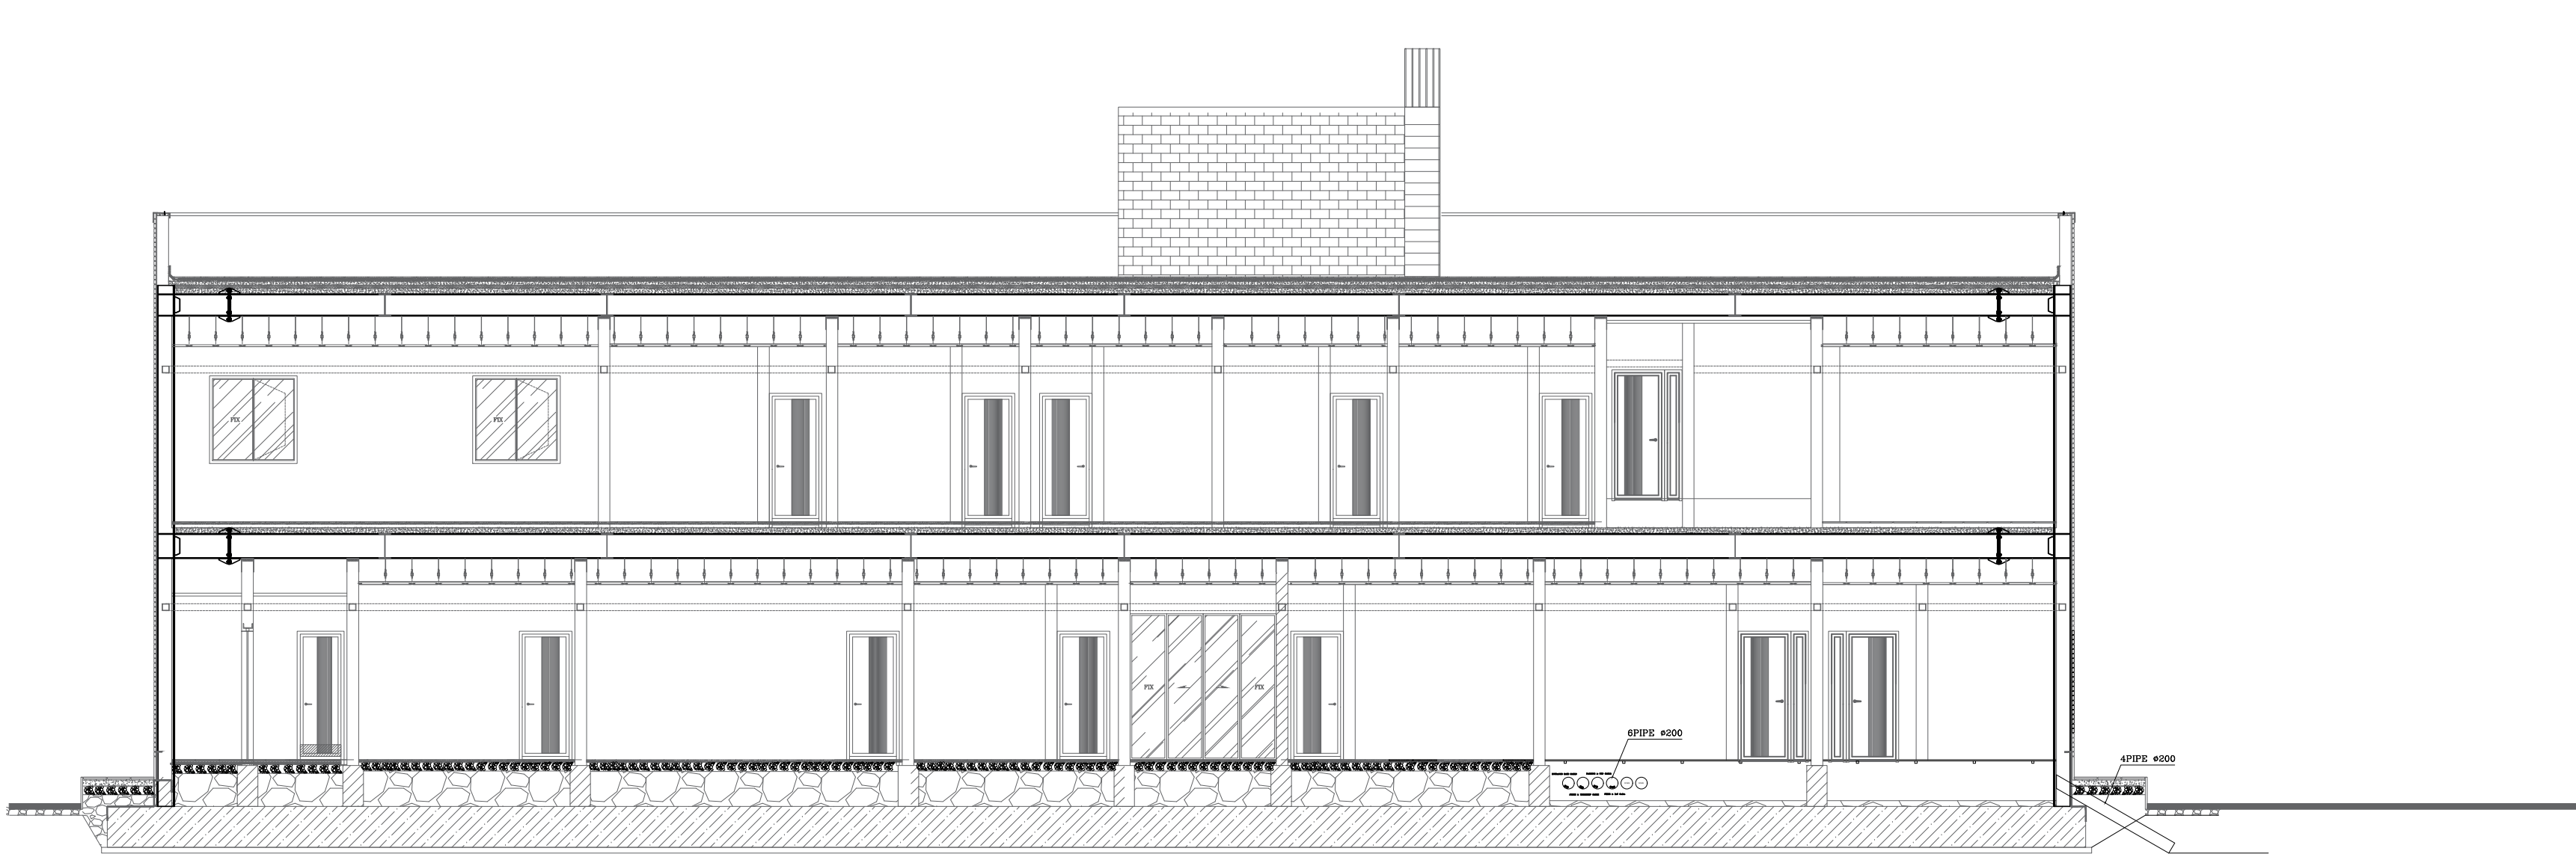

SECTION A-A

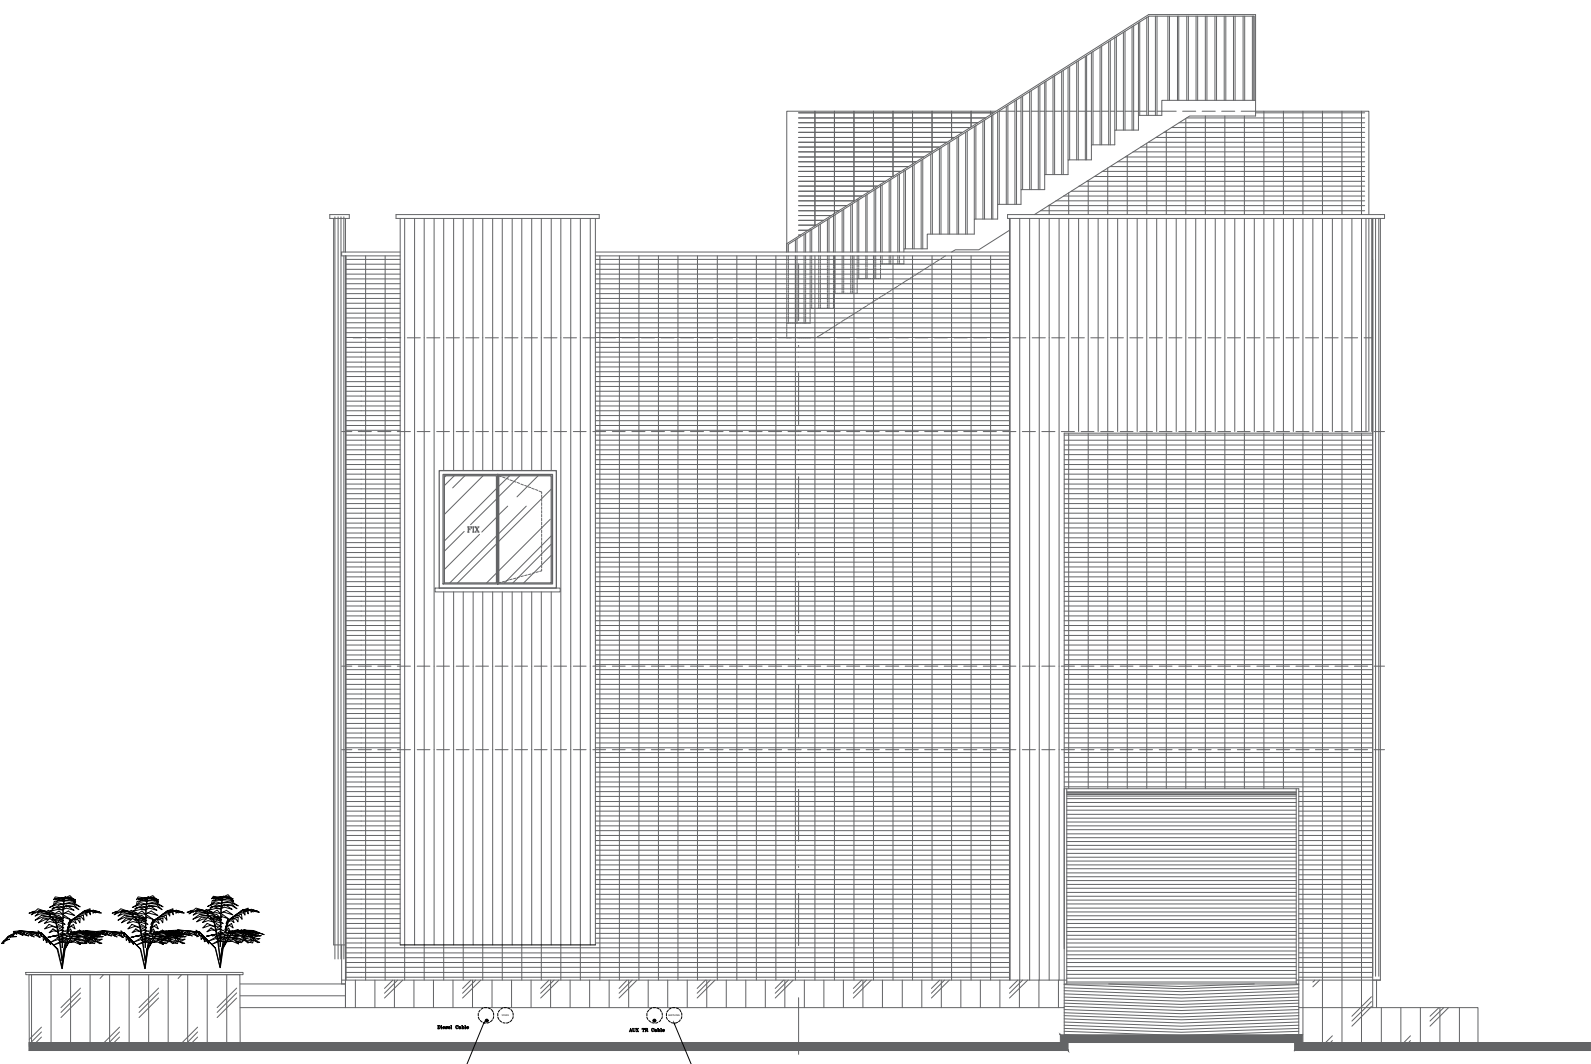

VIEW 4

REFERENCE	
REFERENCE. TITLE	REFERENCE. No.
DC CABLE SIZING CALCULATION & CRITERIA	28P2-B-3MG-CAL-SOL-460001-EL-049
MV CABLE SIZING CALCULATION & CRITERIA	28P2-B-3MG-CAL-SOL-460001-EL-137
LV CABLE SIZING CALCULATION & CRITERIA	28P2-B-3MG-CAL-SOL-460001-EL-117

NOTES	

LEGEND	

KEY PLAN	

REV.	DATE	DESCRIPTION	DESIGN	DRAWN	CHECKED	APPROVED
03	13/07/2026	FORTH ISSUE	M.AMMARI	M.AMMARI	M.DEHESTANI	M.DEHESTANI
02	28/04/2026	THIRD ISSUE	M.AMMARI	M.AMMARI	M.DEHESTANI	M.DEHESTANI
01	27/12/2025	SECOND ISSUE	M.AMMARI	M.AMMARI	M.DEHESTANI	M.DEHESTANI
00	10/11/2025	FIRST ISSUE	M.AMMARI	M.AMMARI	M.DEHESTANI	M.DEHESTANI

Client:			Consultant:			
						
			Contractor:		Sub Contractor:	

Project:						
----------	--	--	--	--	--	--

Title:						
O&M CABLE ROUT						

DOC NO.:	28P2-B-3MG-E33-SOL-460001-EL-197	REV.	
		03	
SCALE	SIZE	SHEET	FORMAT
NTS	A3	17 of 17	DWG